


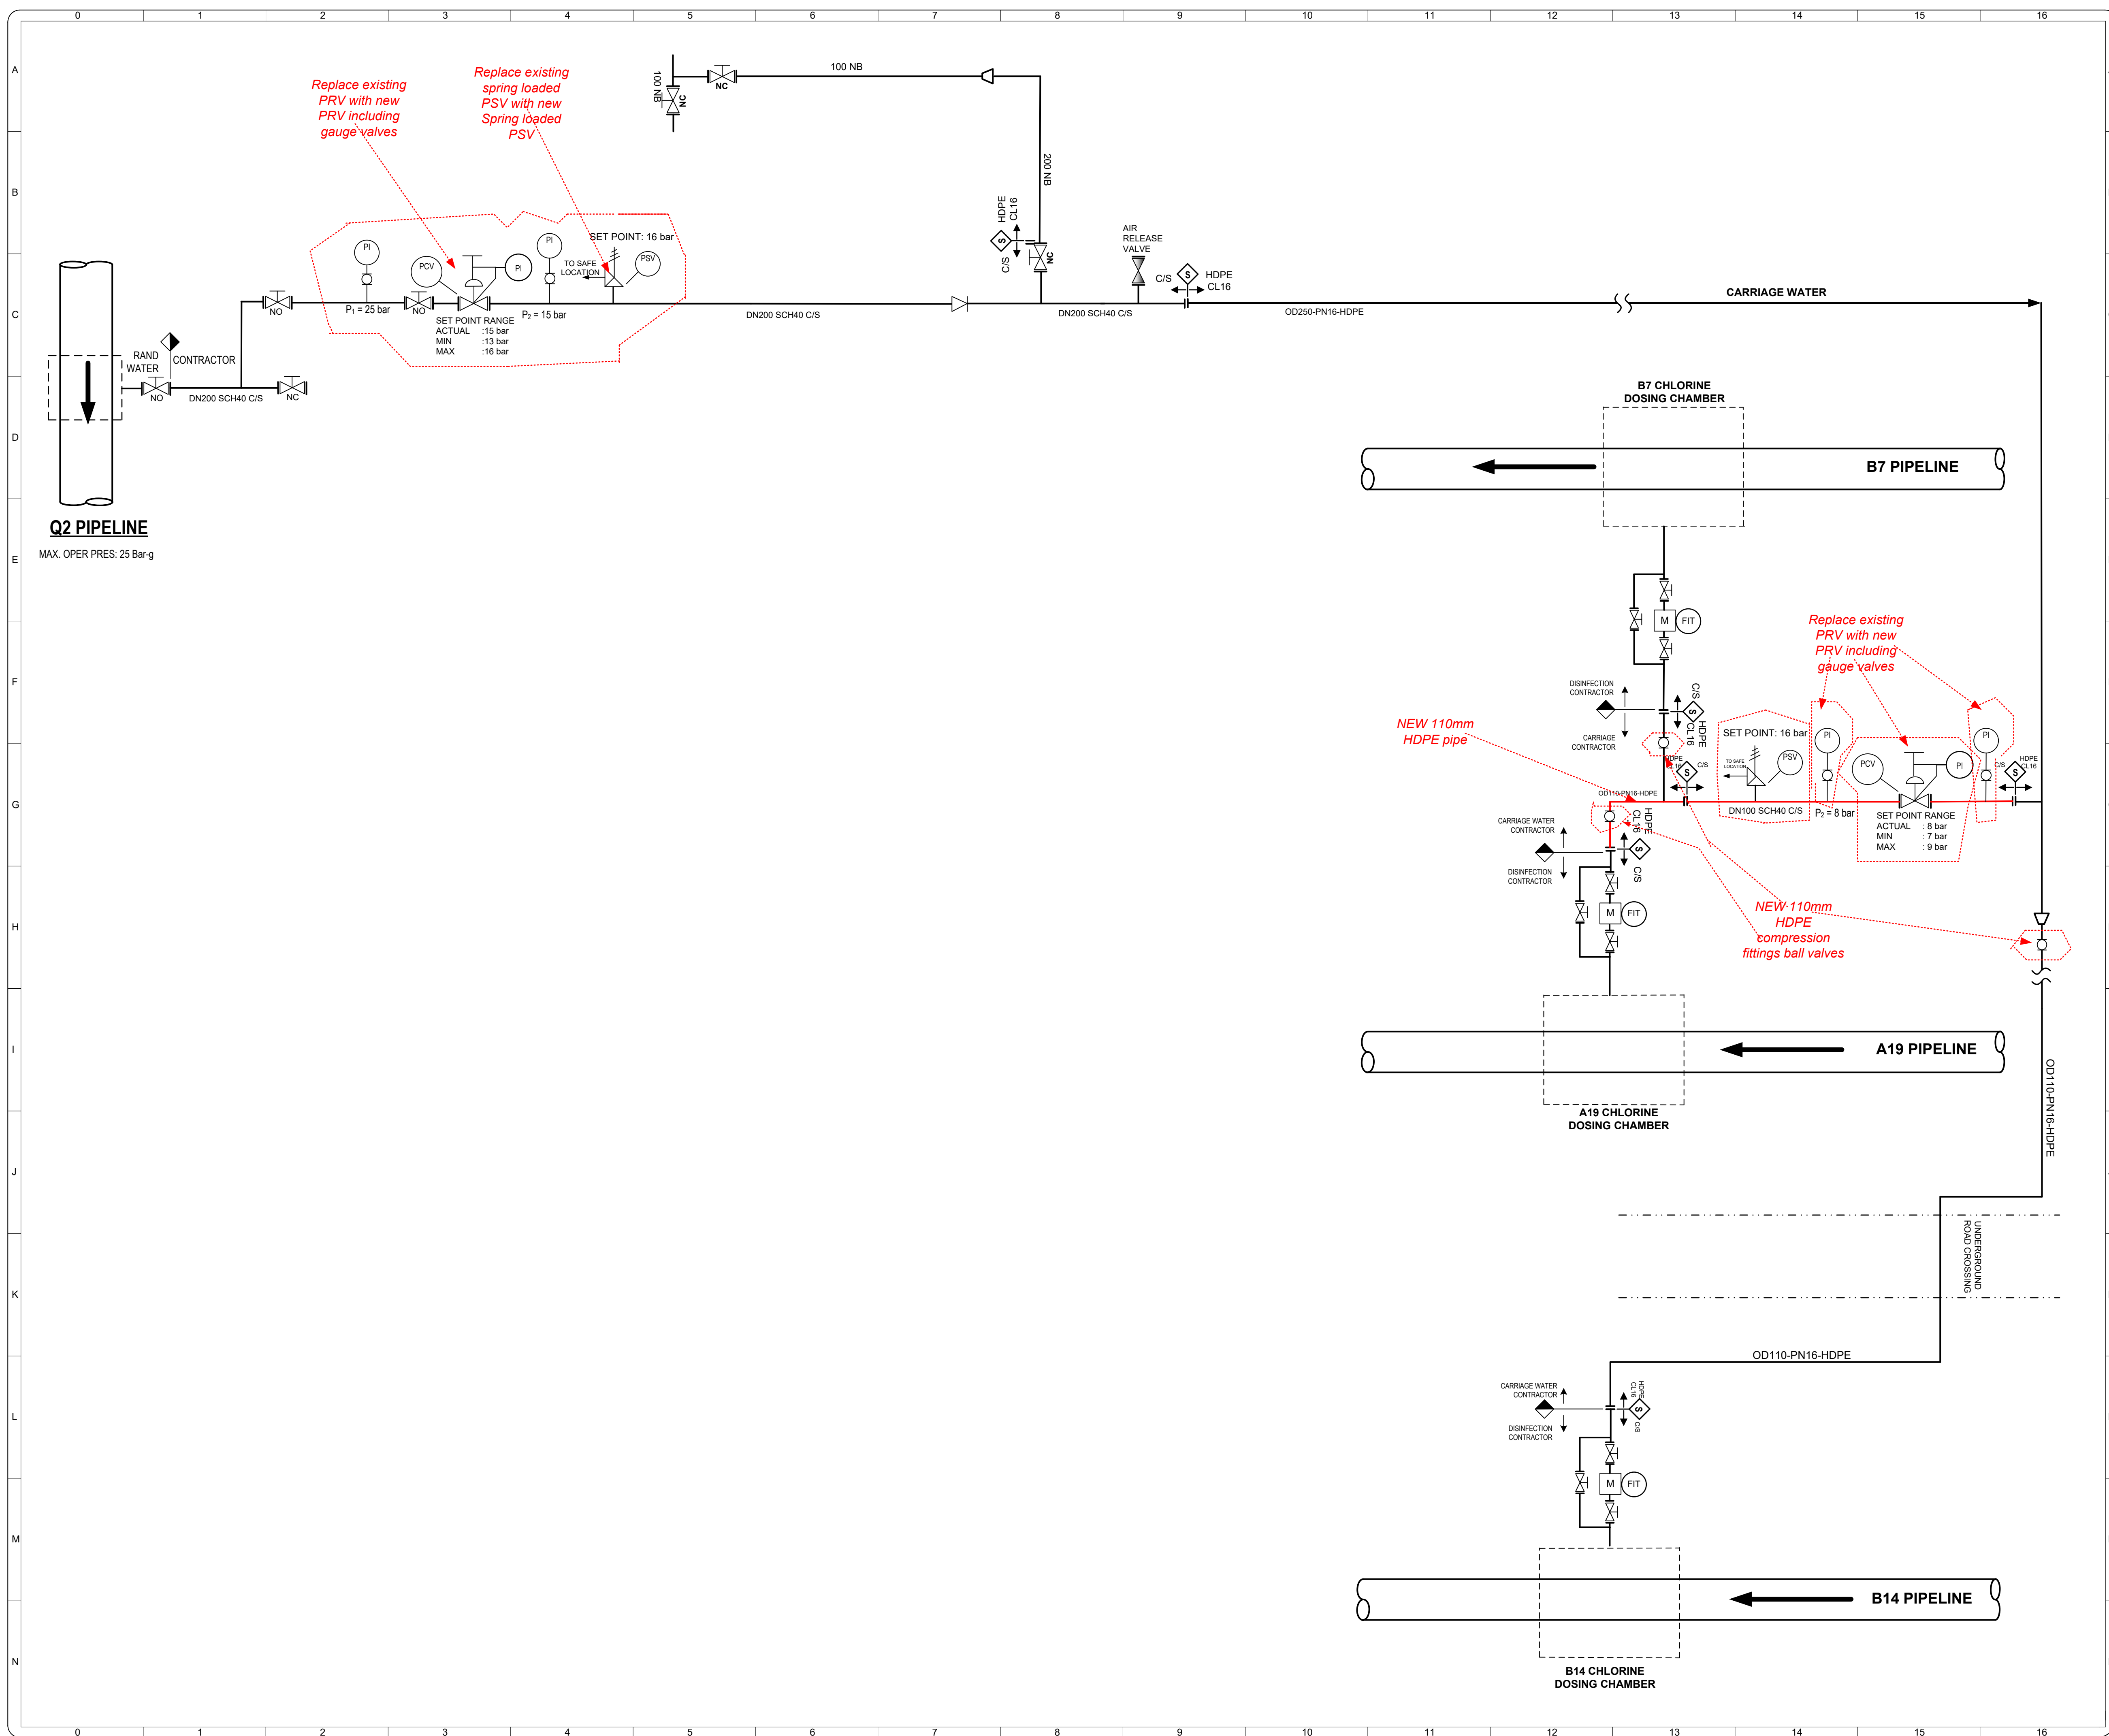

DRG No. RA 39728

GENERAL

1. SYMBOLS USED ON THIS DRAWING TAKEN FROM RAND WATER PROCESS ENGINEERING STANDARD RW-PES-00005 SHEET 1 and 2, AS WELL AS ISA-5.1-1984 (R1992)

NOTES

1. ALL VALVES BEFORE THE FIRST PRESSURE REDUCING VALVES SHALL BE RATED PN35

**FOR TENDER PURPOSE
ONLY**

REVISIONS				
No	DATE	CHECKED	APPROVED	DESCRIPTION
A9499				RAND WATER STANDARDS - PIPING AND INSTRUMENTATION DIAGRAMMS - SHEET 1 OF 2
A9500				RAND WATER STANDARDS - PIPING AND INSTRUMENTATION DIAGRAMMS - SHEET 2 OF 2
NUMBER			TITLE	
REFERENCE DRAWINGS				



RAND WATER

BOX 1127
JOHANNESBURG
2000
TEL: 682-0911

SAP No.	P.03797	CHECKED	
CONTRACT No.	RWXXXX/1X	SECTION HEAD	
ORIGINATOR		APPROVED	_____
DRAWN BY	R. MSWELI	CAPACITY	_____
DATE	30/01/2020	DATE	_____

EIKENHOF PUMPING STATION CARRIAGE WATER FOR COMMISSIONING

PIPING AND INSTRUMENTATION DIAGRAM

SCALE N.T.S.

STATION	WKS	DOC. TYPE	S
---------	-----	-----------	---

[illegible]

DRG No. RA 39728

A1	$\angle$
----	----------

